

NOTES:

3 K5/DW, 2"5, 1½"V. OR INSTALL 1½" MINI STUDOR VENT.

5 1½ 'VTR, MAINTAIN 10 FT. CLEARANCE TO FRESH AIR INTAKES.

6 2'VTR, MAINTAIN 10 FT. CLEARANCE TO FRESH AIR INTAKES.

8 CONTINUATION TO EXISTING CITY SANITARY WASTE SYSTEM REFER TO CIVIL UTILITY SITE PLAN.

GAS TANKLESS WATER HEATER. ROUTE CONCENTRIC VENT UP THRU ROOF, MAINTAIN 10 FT. CLEARANCE TO FRESH AIR INTAKES.

2 15, $1\frac{1}{2}$ V, TO DUEL CLOTHES WASHER BOX.

1 2"9, DOWN FROM ABOVE

3 '5, DOWN FROM ABOVE.

2 L, SH, 2"S, 1½"V.

7010 Easy Wind Dr. Ste 200 Austin, TX 78752 512.899.3100


www.designopa.com





2018 OPA Design Studio. All Rights Reserved. These designs / drawings are the sole property of the Architect, OPA Design Studio. They may not be reproduced in any form, by any method, for any purpose without previous written permission from the Architect.

from the Architect.	
JOB NO.:	201724-A
PHASE:	CD
DRAWN:	SO, LE
CHECKED	: SO
DATE:	10/22/2018

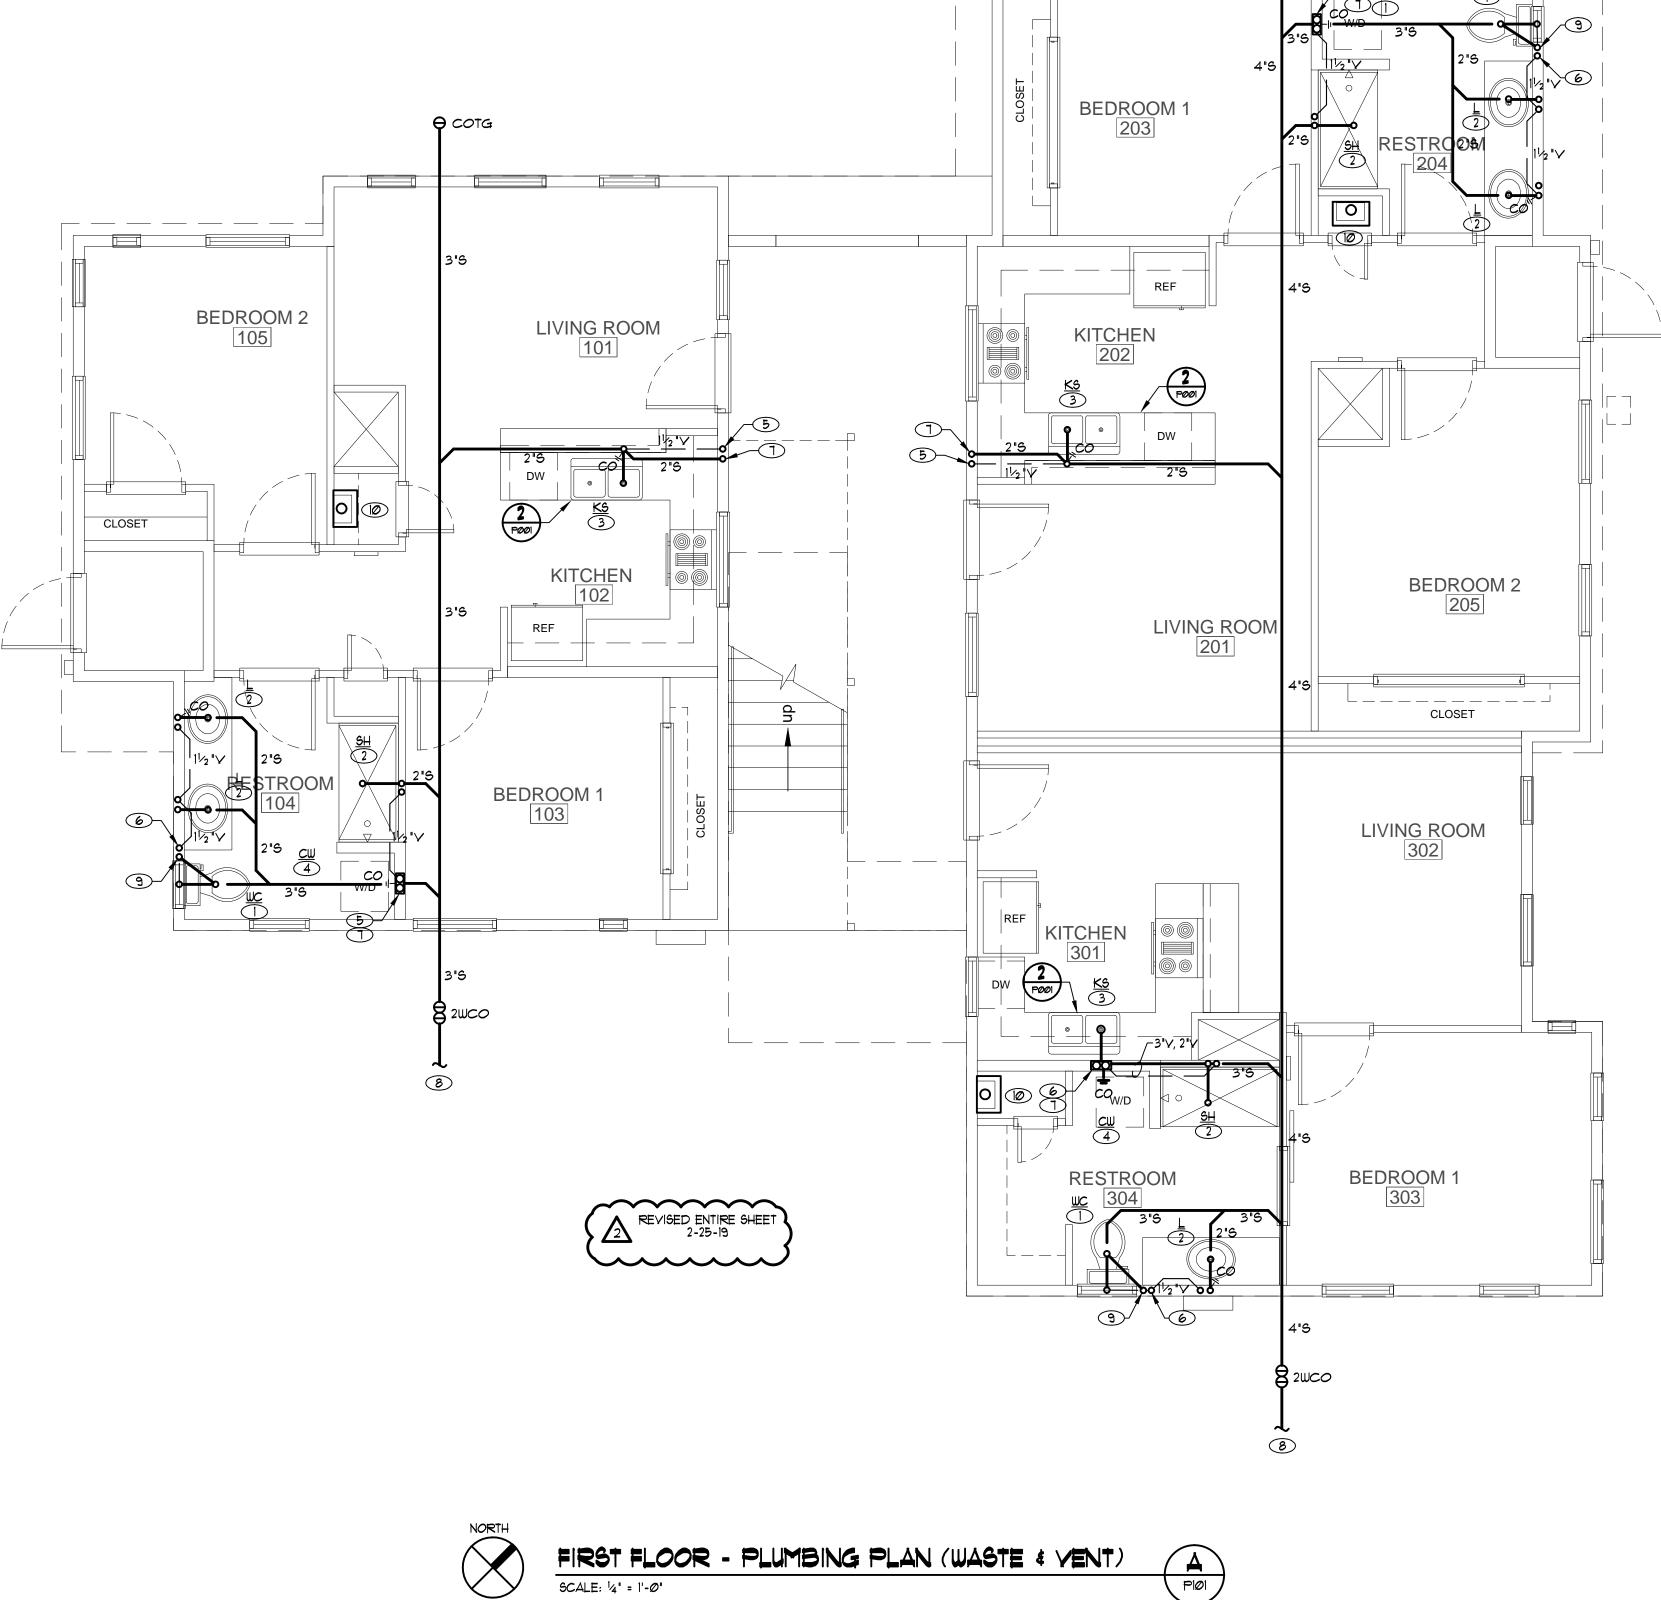

 Θ cota